



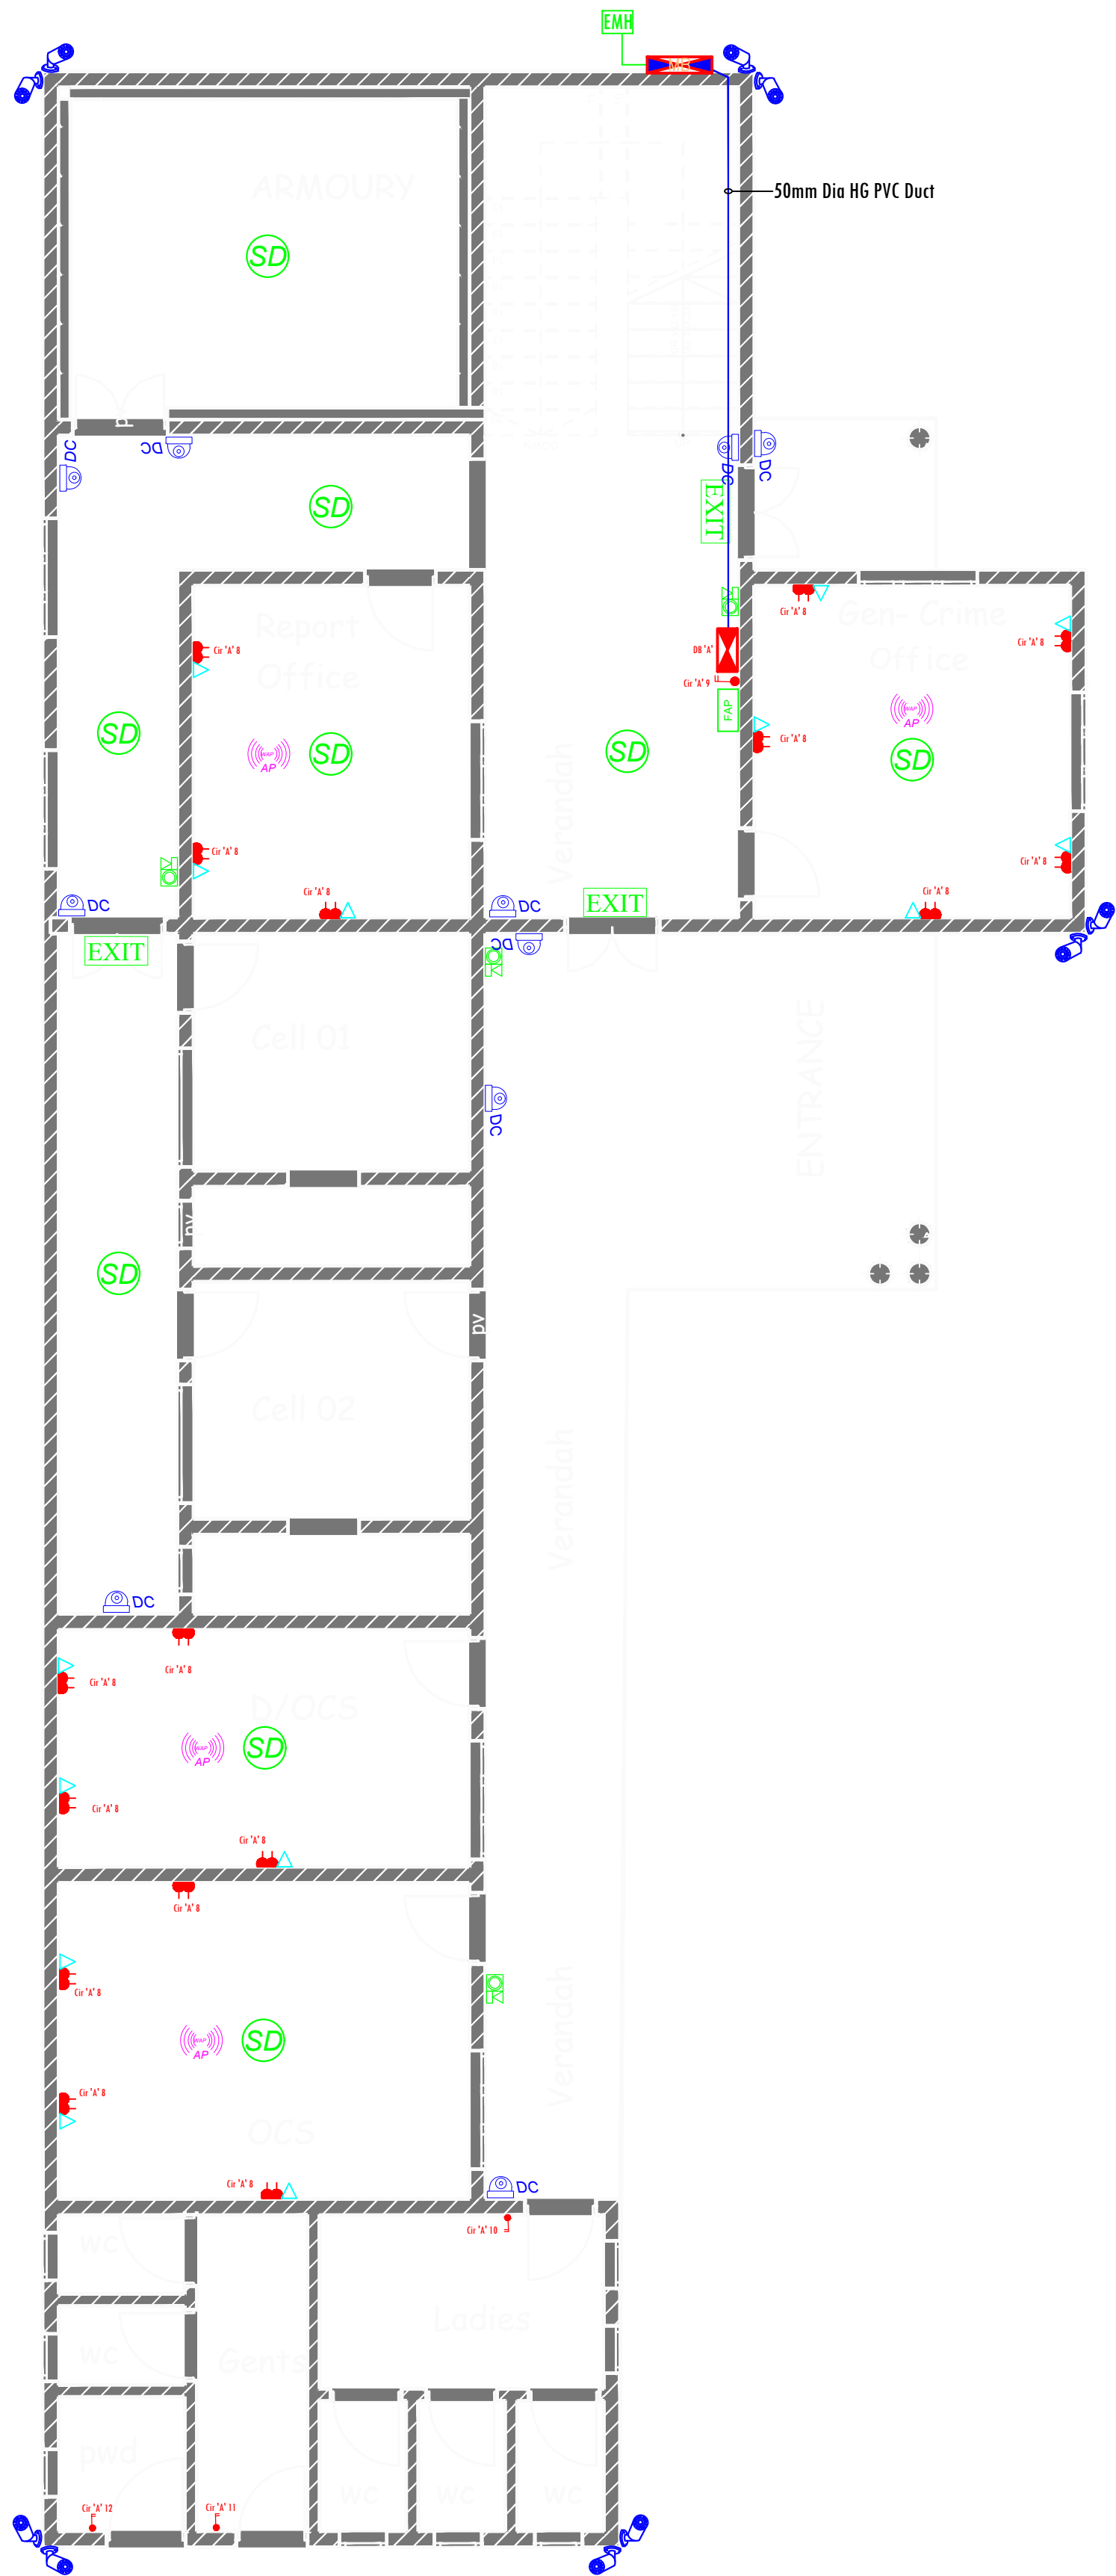

GROUND FLOOR POWER, DATA/WIRELESS,
CCTV & FIRE ALARM LAYOUT

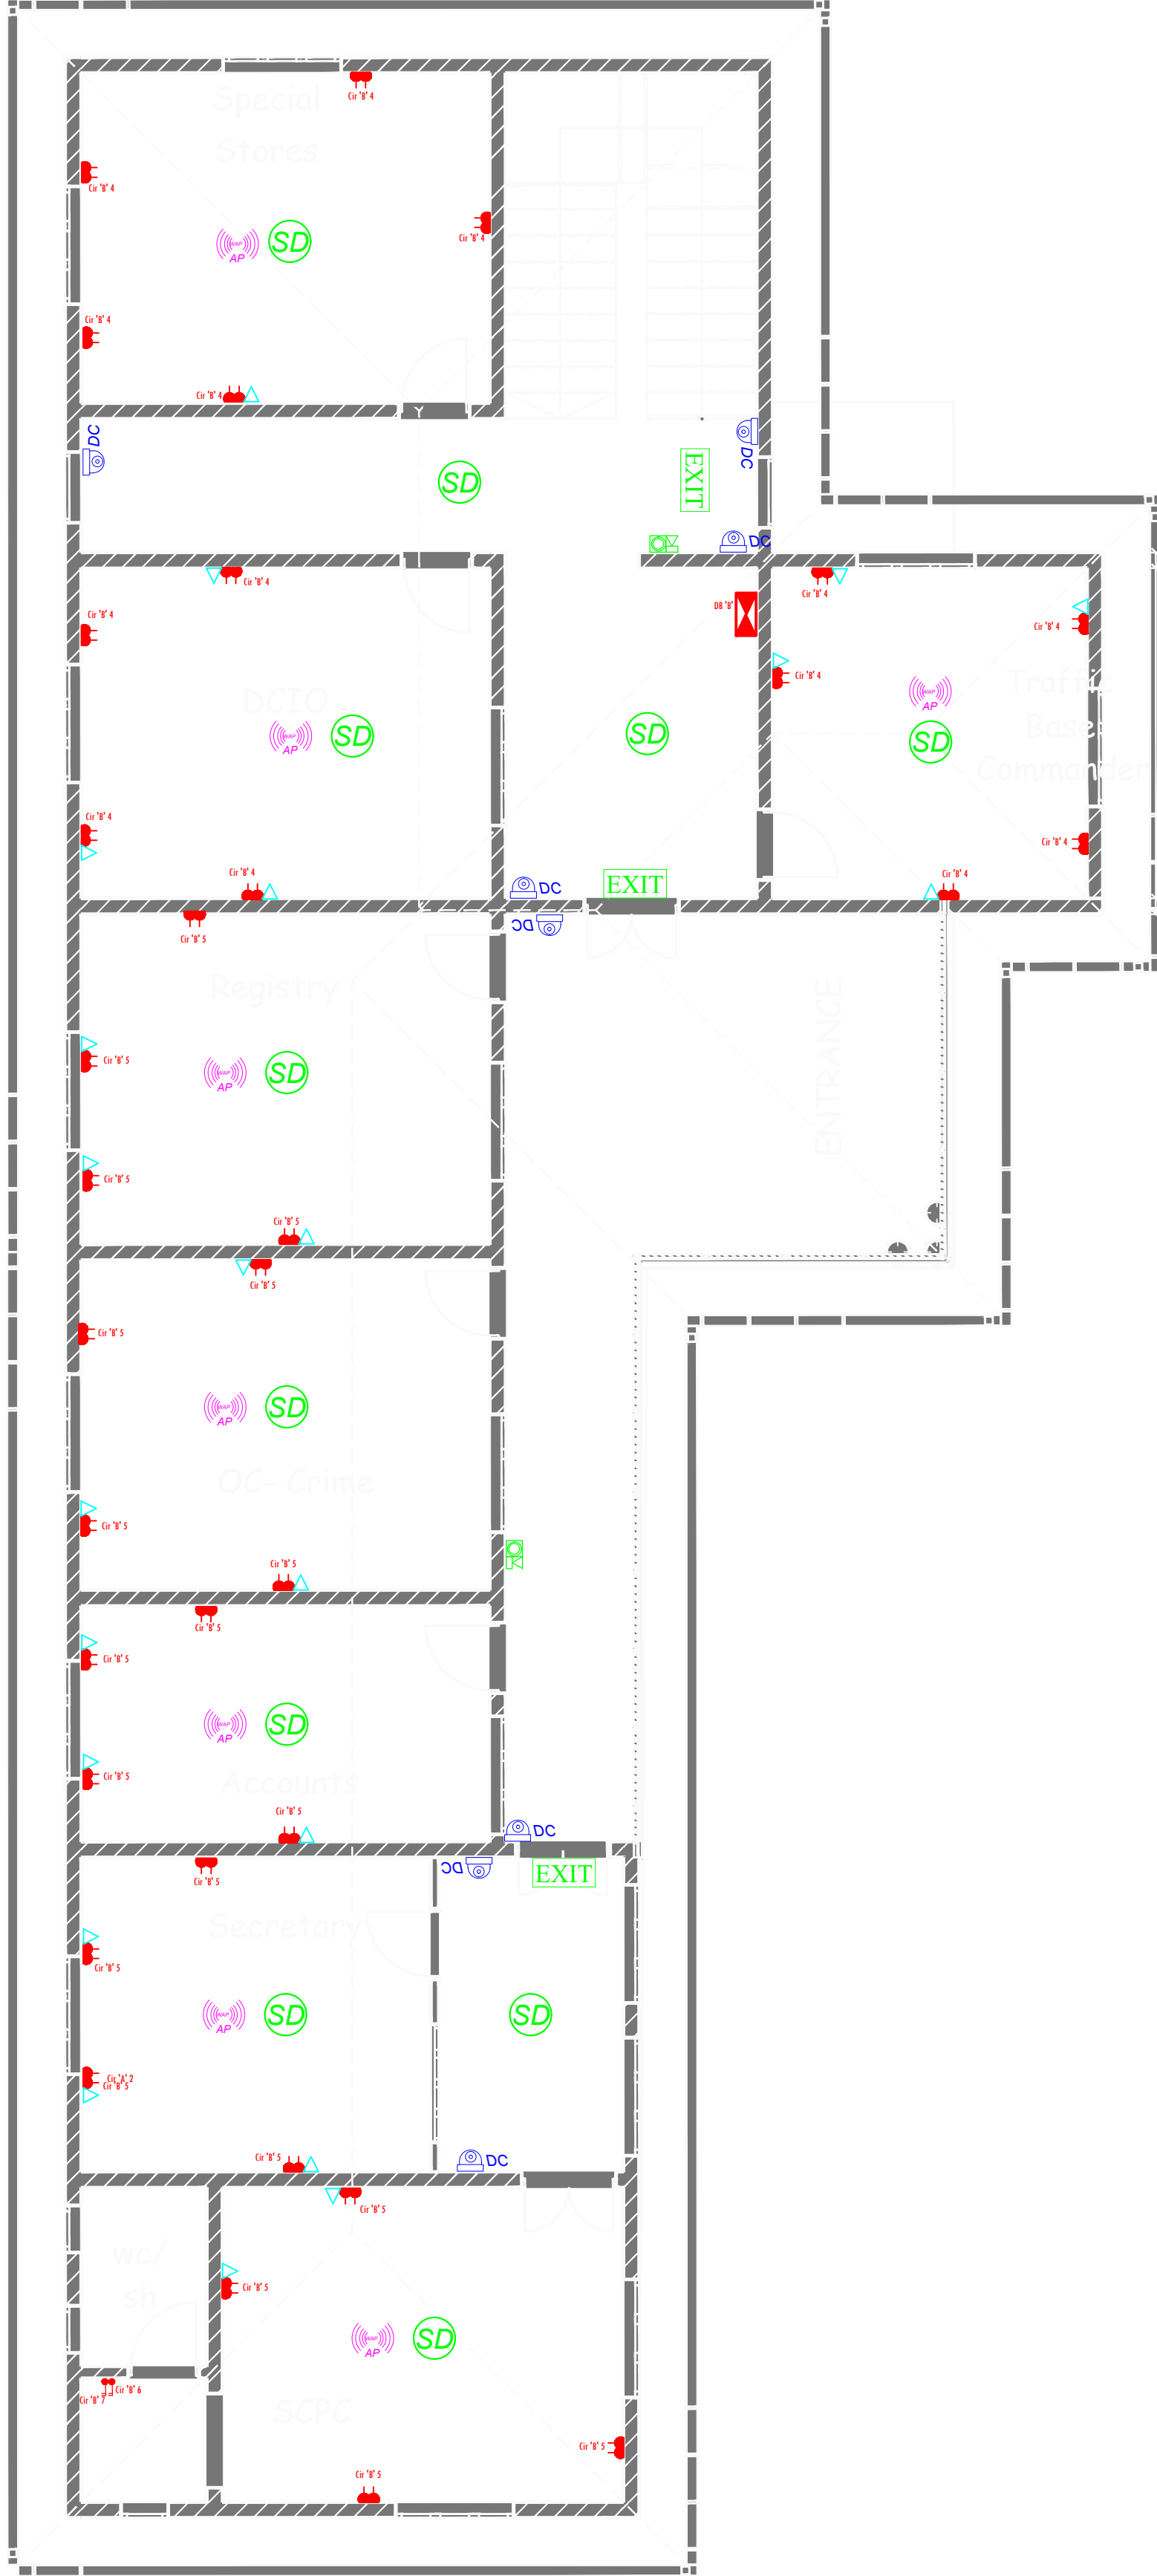

1ST FLOOR POWER, DATA/WIRELESS,
CCTV & FIRE ALARM LAYOUT

NOTES

- 1) Drawing Shall be read together with Architects,Civil Engineers and Mechanical Engineers Drawings. Any discrepancies MUST be reported to the Engineers.
- 2) All samples shall be approved before Installation commences.
- 3) This drawing must be checked against existing site conditions and any discrepancies MUST be reported to the Engineers.
- 4) All cables should be copper
- 5) All lighting switches shall be mounted at the height of 1350mm a.f.f.l. unless otherwise stated.
- 6) All socket outlets shall be mounted at the height of 300mm a.f.f.l. unless otherwise stated.
- 7) All distribution boards and consumer units shall be mounted at the height of 1800mm a.f.f.l. unless otherwise stated.
- 8) All lighting circuits shall be 2x1.5 sq. mm PVC SC + 1.5 sq. mm e.c.c copper cables unless otherwise specified.
- 9) All ring mains circuits shall be 2x2.5 sq. mm PVC SC + 2.5 sq. mm e.c.c copper cables unless otherwise specified.

REVISIONS

Rev No.	DATE	BY	DESCRIPTION	SIGNATURE

CLIENT NG-CDF - MUKURWE-INI,
P.O BOX
MUKURWE-INI.


SIGN

PROJECT
PROPOSED KANGURWE POLICE STATION

DRAWING TITLE
POWER, DATA/WIRELESS, CCTV
& FIRE ALARM DRAWINGS

SCALES	DRG NO		
NTS	E/ 02.		
	NAME	SIGNATURE	DATE
DESIGNED	D.M.G		SEPTEMBER, 2026
DRAWN	D.M.G		SEPTEMBER, 2026
CHECKED	RWO: QS. K. NG'ANG'A		SEPTEMBER, 2026

MINISTRY OF LANDS, PUBLIC WORKS, HOUSING AND URBAN DEVELOPMENT

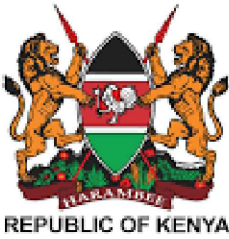

STATE DEPARTMENT
FOR PUBLIC WORKS
Public Works Makes Kenya Work